March 4, 2019

The following Clarifications (1, 2, and 3) will serve as Amendment #2 to NYSIF's Invitation for Bid (IFB) for Furniture and Equipment Removal Disposal, bid number 2019-07-RE. Material in this Amendment supersedes any contradictory material in the IFB.

### Clarification number 1:

The use of a demolition bridge to remove materials through a window is allowed for this operation. The CONTRACTOR must provide engineered stamped plans of the bridge to be used with a safety plan for approval. Insurance requirement for the use of the demolition bridge will be increased to \$3,000,000 per occurrence/\$5,000,000 aggregate.

### Clarification number 2:

A current floor plan 2 is being added to the IFB as Exhibit 2. It is for reference and planning only. The information on this floor plan is outdated.


## Clarification number 3:

Materials being removed include, but are not limited to modular workstations and panels, end tables, folding tables, chairs, shelving, file cabinets, chair mats, and accessories. NYSIF will clearly mark any materials which are NOT to be removed.

Please note that the due date for the submission of bids **remains unchanged**.

All bids are due March 14th, 2019 by 2:00 p.m.(eastern).

Sincerely,

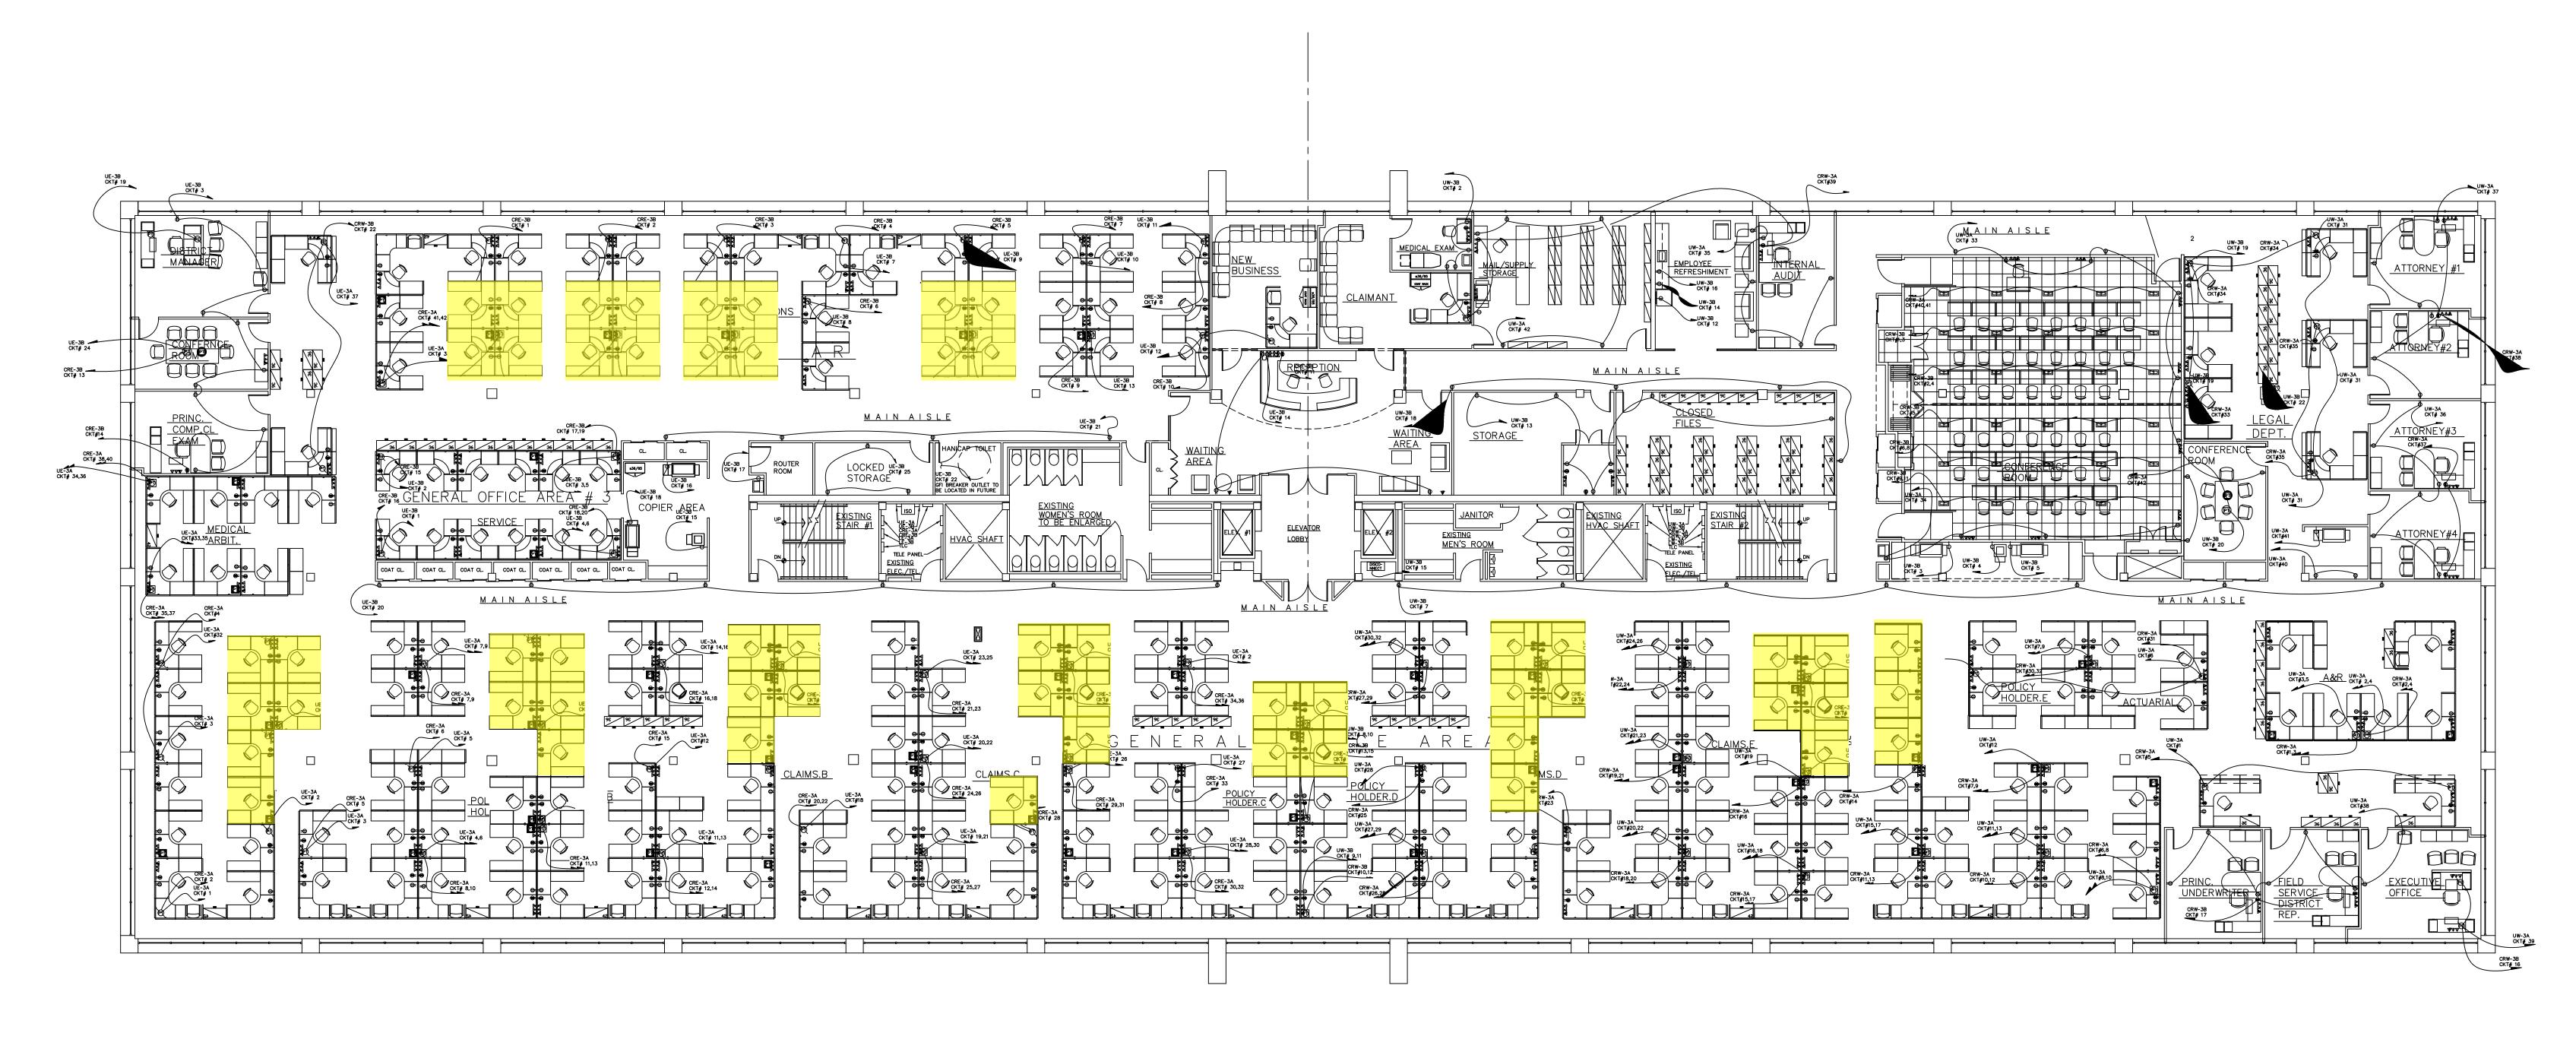



<u>THIRD FLOOR POWER PLAN</u>

# WALKER RCI RC-900 QUAD SERIES POKE THROUGH WITH DUPLEX RECEPTACLES; JUNCTION BOX, AND BLACK, FINISHING RING

- WALKER RCI RC-900 QUAD SERIES POKE THROUGH WITH, TWO DATA DATA OUTLETS, JUNCTION BOX, AND BLACK, FINISHING RING
- WALKER RCI FIT SERIES POKE THROUGH WITH, FLOOR MOUNTED JUNCTION BOX.
- DATA POKE THROUGH WITH EGS NELSON CAFSI SMO AND FIRE STOP HARD-WHERE.
- ISO 30KVA ISOLATION TRANSFORMER
- TWO SECTION FLOOR BOX AS SUPPLIED BY FLOOR SYSTEM MANUFACTURER.

# ASBUILT DRAWINGS

|  | 10-05-99 R  |         | REVISIO | REVISIONS AS PER BLDG. DEPT. COMMENTS |                        |         | SAL.P |
|--|---|---------|---------|---------------------------------------|------------------------|---------|-------|
|  | 9/10/99 REVISIONS TO POWER CIRCUITS   |         |         |                                       |                        |         |       |
|  | NO. DATE REVISION   |         |         |                                       |                        | BY      |       |
| MARNING: ALTERATIONS OF THIS<br>DOCUMENT EXCEPT IN ACCORD—<br>ANCE WITH NEW YORK STATE<br>EDUCATION LAW, SECTION 7209,<br>SUBDIVISION 2, IS ILLEGAL. | THIRD FLOOR POWER PLAN. (SUFFOLK COUNTY OFFICE)   |         |         |                                       |                        |         |       |
|  | PROJECT: NEW YORK STATE INSURANCE FUND INTERIOR OFFICE CONSTRUCTION AT 8 CORPORATE CENTER DRIVE, MELVILLE, NEW YORK |         |         |                                       |                        |         |       |
| BOWNE  |   |         |         |                                       |                        |         |       |
|  | Sidney B. Bowne & Son CONSULTING ENGINEERS  235 E. Jericho Tpke. P.O. Box 109 Mineola, NY 11501 (516) 746-2350      |         |         |                                       |                        |         |       |
|  | DESIGN  | l: T.R. |         | DRAWN: T.R.                           | CHECKED:               | SHEET _ | E-3   |
|  | SCALE:  | AC NOTE | _       | DATE:                                 | PPO IECT No.: 10040011 | ا ا     |       |

M:\Engineering\Corp\_Ctr\_D